



4 BR / TYPE / ACACIA PHASE II / KITENGELA

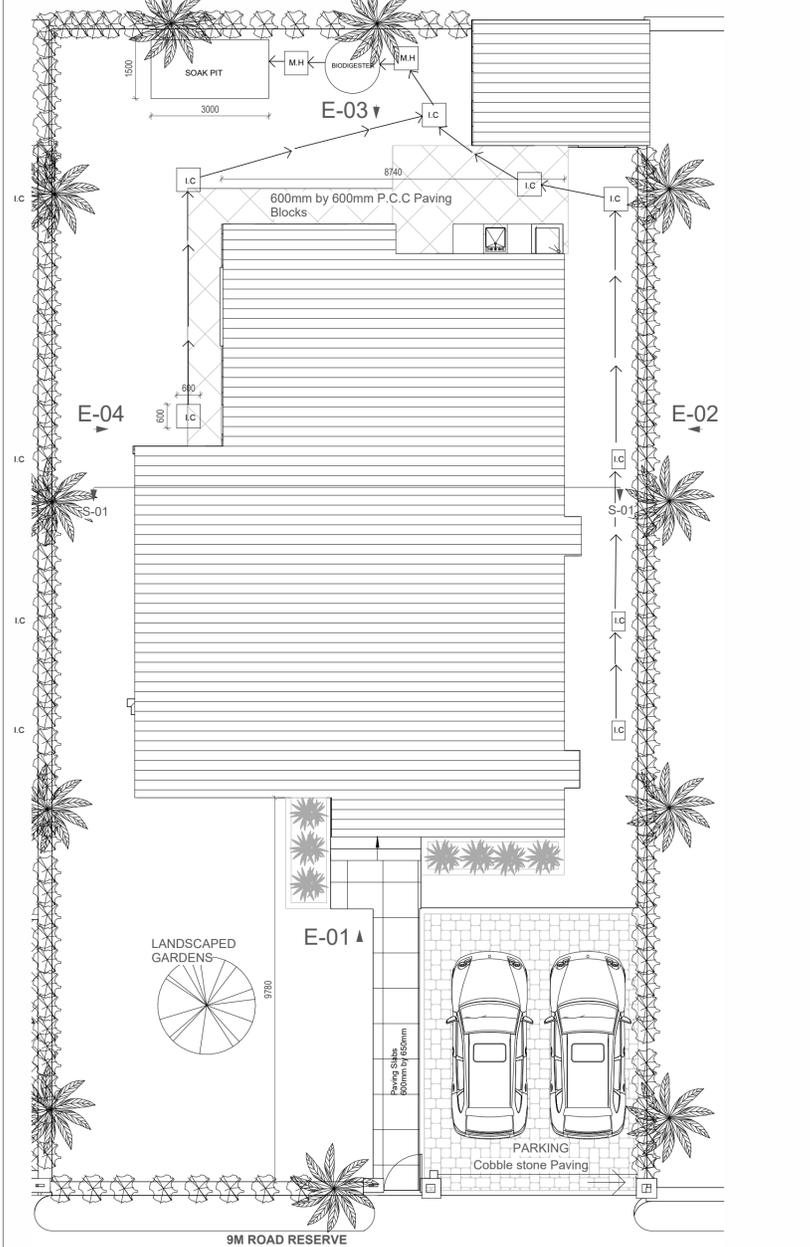


SITE PLAN 1:100

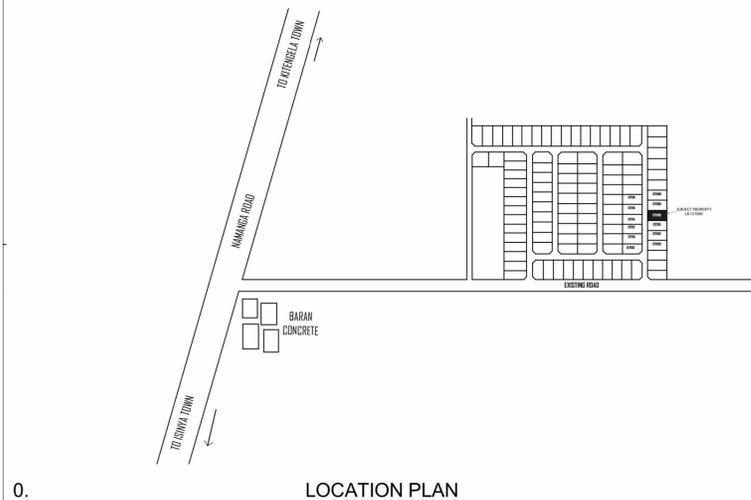


0. LOCATION PLAN 1:100


PROJECT :PROPOSED FOUR BEDROOM RESIDENTIAL HOUSE AT KITENGELA ACACIA PHASE II.

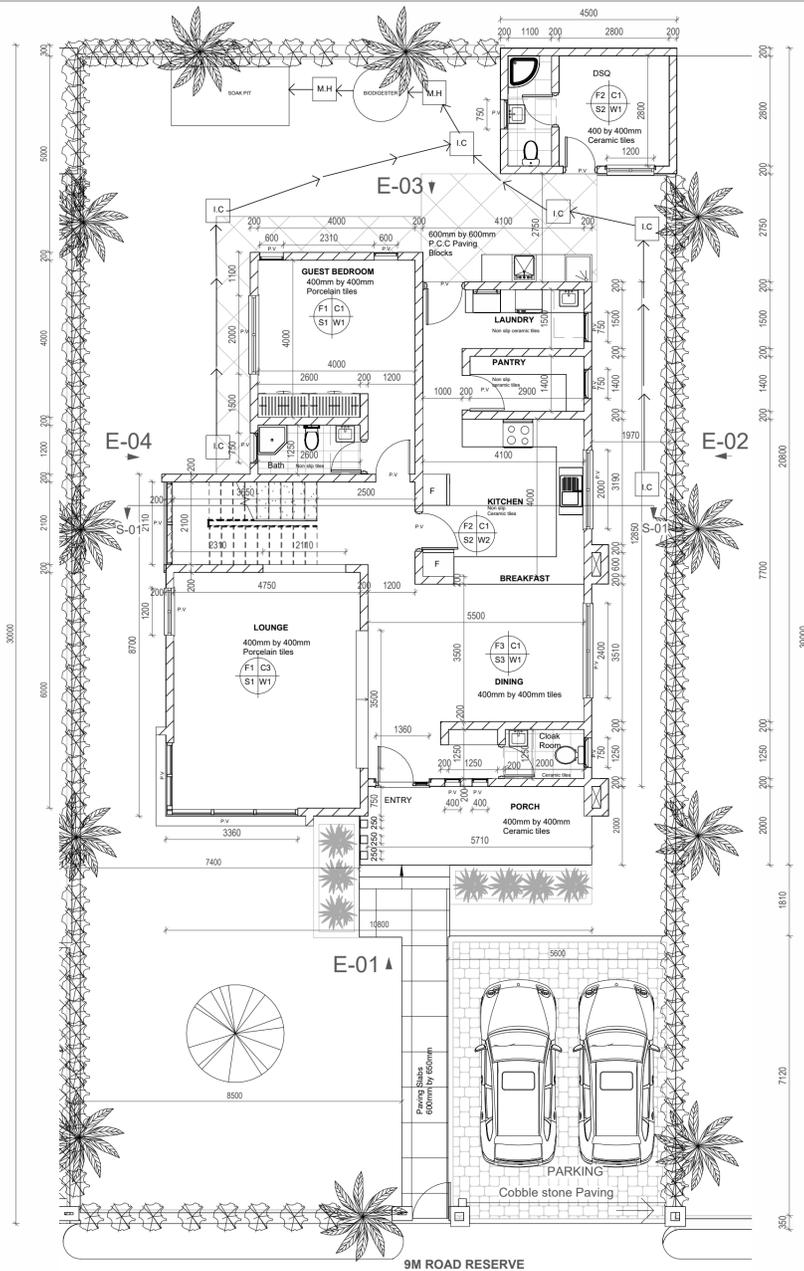


0. GROUND FLOOR PLAN 1:100

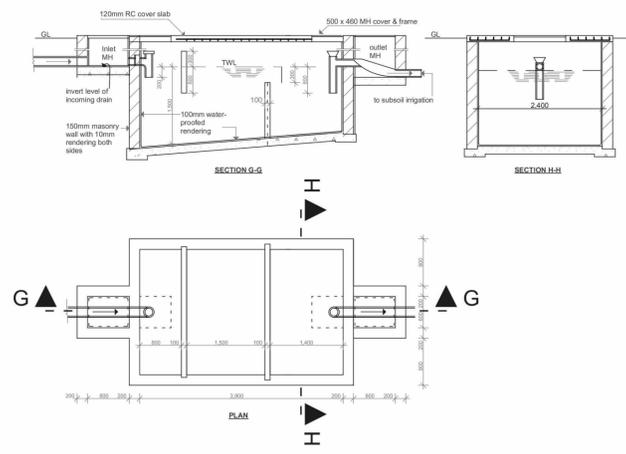

SEPTIC TANK DETAIL 1:67.96

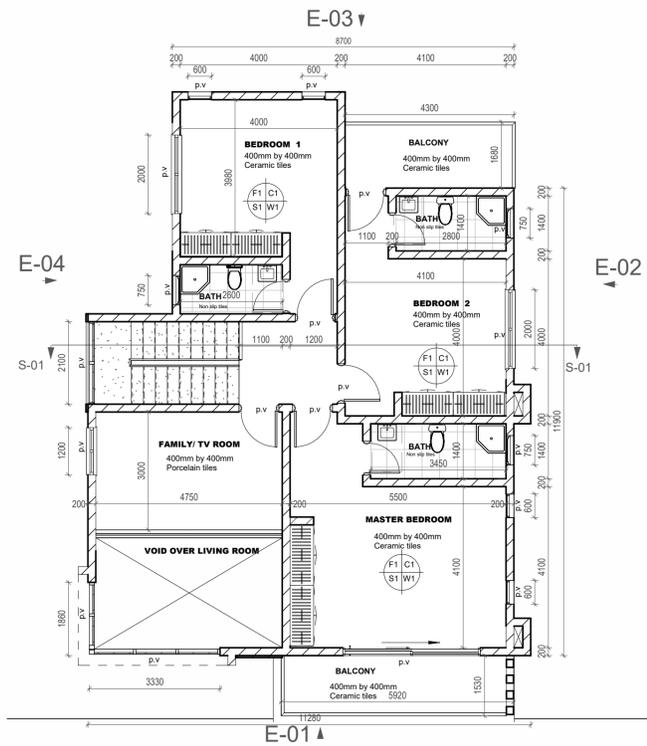

1. FIRST FLOOR PLAN 1:100

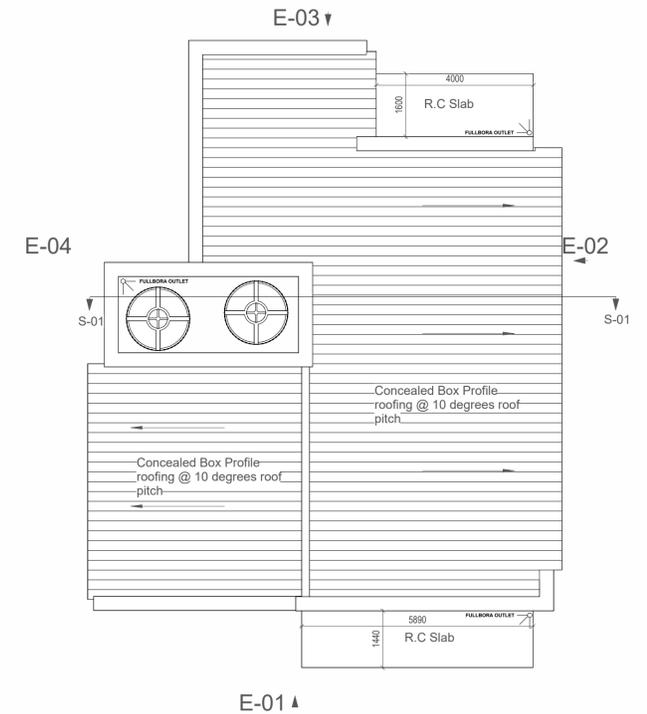

2. ROOF PLAN 1:100

Notes

All internal fittings to architects design and details
 Metal gutters and down pipe to suite
 All dimensions and levels to be checked on site and any discrepancies referred to architect before commencement of works
 All dimensions in mm
 P.V denotes permanent air vent
 All balustrading to staircase to details.
 All walls under 200mm thick to be reinforced every alternate course with hoop iron
 All soil and waste pipes under paved areas ,floors drives and walls to be encased in 100mm concrete surround
 All Windows and doors to schedule and details
FIRE SAFETY Fire detection and fire alarm system SHALL COMPLY WITH BS 5839-1 for buildings. Code of practice for design, installation and commissioning and maintenance of systems in non-domestic premises
 The Architect asserts his rights to be identified as the author of this work under Cap 130,Copyright act, Laws of Kenya.

Revisions

23.10.2025
 Amended 4BR Typology to reduce area as per the Client project meeting of 21.10.2025

CLIENT

PARLIAMENTARIANS HOUSING CO-OPERATIVE SOCIETY

LR NOs :

Kajiado/ Kaputei North / 137091

Clients Signature :

JOB NO.RAC/0208_2025/PAHOCO

PROPOSED FOUR BEDROOM RESIDENTIAL HOUSE AT KITENGELA ACACIA PHASE II.

Stage OUTLINE PROPOSAL

Scale As Shown

Drawn Renaissance Architects

Designed G.N

Checked Gideon Ngumbau , A1545

RENAISSANCE AFRICA CONSULT
 Architects & Projects Managers
 P.O BOX 67897-00200
 NAIROBI



Date : 23RD OCTOBER 2025

Sheet. Title : Outline Proposal



Drawing No As shown

A.01

2 of 2 PAHOCO Housing 4
 BEDROOM_ Reduced
 File Typologies Plan_October 2025.pln

CLIENT : PARLIAMENTARIANS HOUSING CO-OPERATIVE SOCIETY

4BR / TYPE / ACACIA PHASE II / KITENGELA

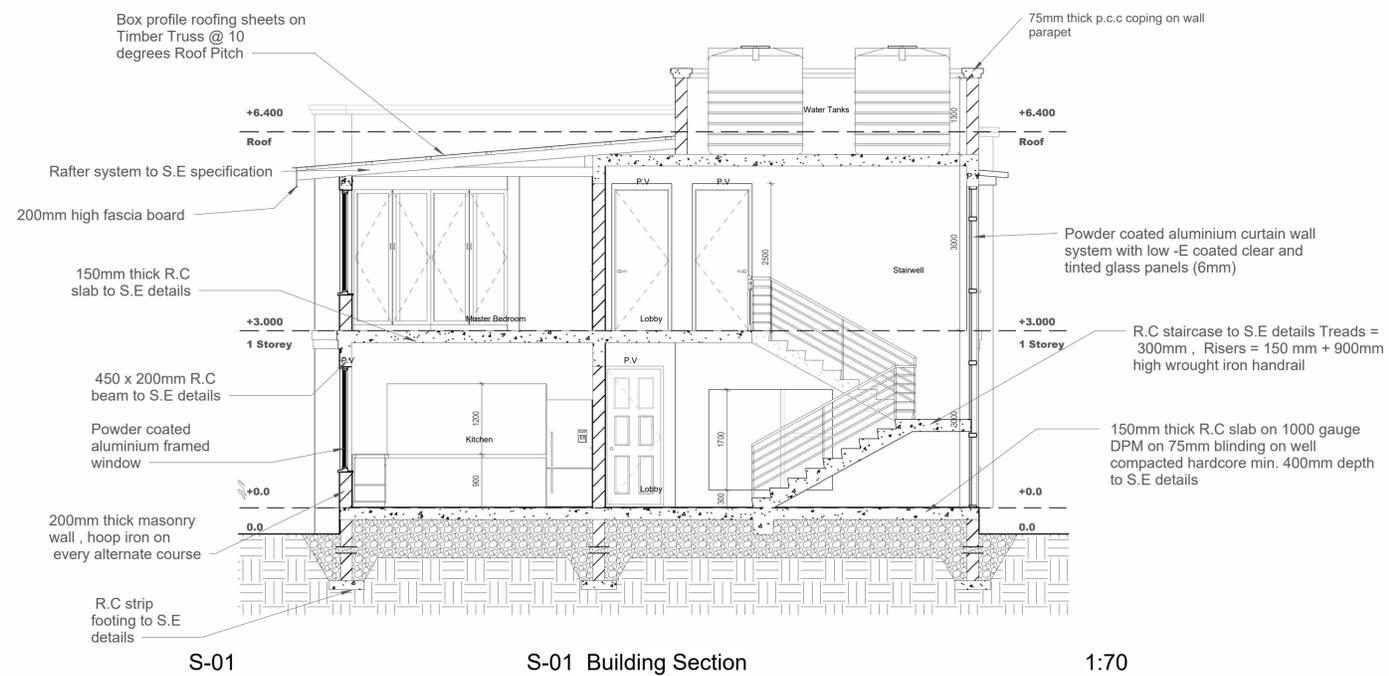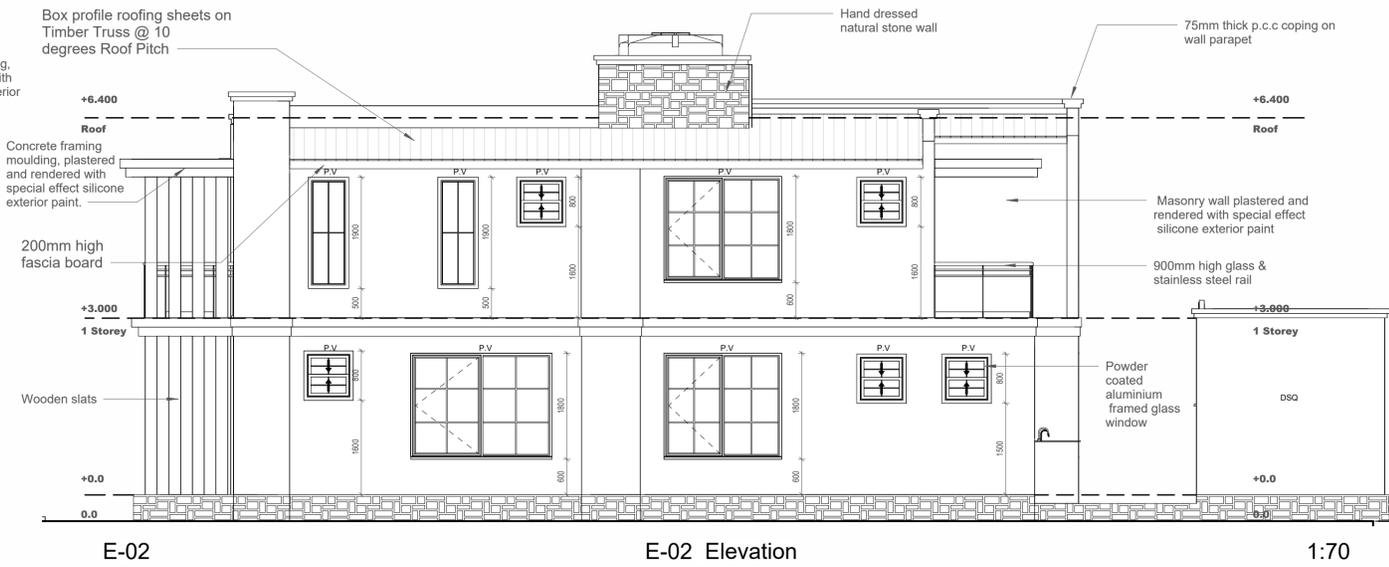

Notes

- All internal fittings to architects design and details
- Metal gutters and down pipe to suite
- All dimensions and levels to be checked on site and any discrepancies referred to architect before commencement of works
- All dimensions in mm
- P.V denotes permanent air vent
- All balustrading to staircase to details.
- All walls under 200mm thick to be reinforced every alternate course with hoop iron
- All soil and waste pipes under paved areas ,floors drives and walls to be encased in 100mm concrete surround
- All Windows and doors to schedule and details
- FIRE SAFETY** Fire detection and fire alarm system SHALL COMPLY WITH BS 5839-1 for buildings. Code of practice for design, installation and commissioning and maintenance of systems in non-domestic premises
- The Architect asserts his rights to be identified as the author of this work under Cap 130, Copyright act, Laws of Kenya.

Revisions

- 23.10.2025
- Amended 4BR Typology to reduce area as per the Client project meeting of 21.10.2025

CLIENT

PARLIAMENTARIANS HOUSING CO-OPERATIVE SOCIETY

LR NOs :

Kajiado/ Kaputei North / 137091

Clients Signature :

JOB NO.RAC/0208_2025/PAHOCO

PROPOSED FOUR BEDROOM RESIDENTIAL HOUSE AT KITENGELA ACACIA PHASE II.

Stage OUTLINE PROPOSAL

Scale As Shown

Drawn Renaissance Architects

Designed G.N

Checked Gideon Ngumbau , A1545

RENAISSANCE AFRICA CONSULT Architects & Projects Managers P.O BOX 67897-00200 NAIROBI



Date : 23RD OCTOBER 2025

Sheet Title : Outline Proposal

Drawing No As shown

A.01

2 of 2 PAHOCO Housing 4 BEDROOM_Reduced File Typologies Plan_October 2025.pln